


ROOF-MOUNTED PV PANELS  
SUBJECT TO SPECIALIST DESIGN

EAVES GUTTER

FALL RESTRAINT SYSTEM FOR MAINTENANCE OF PV TO BE  
DESIGNED BY SPECIALIST - NOT SHOWN FOR CLARITY

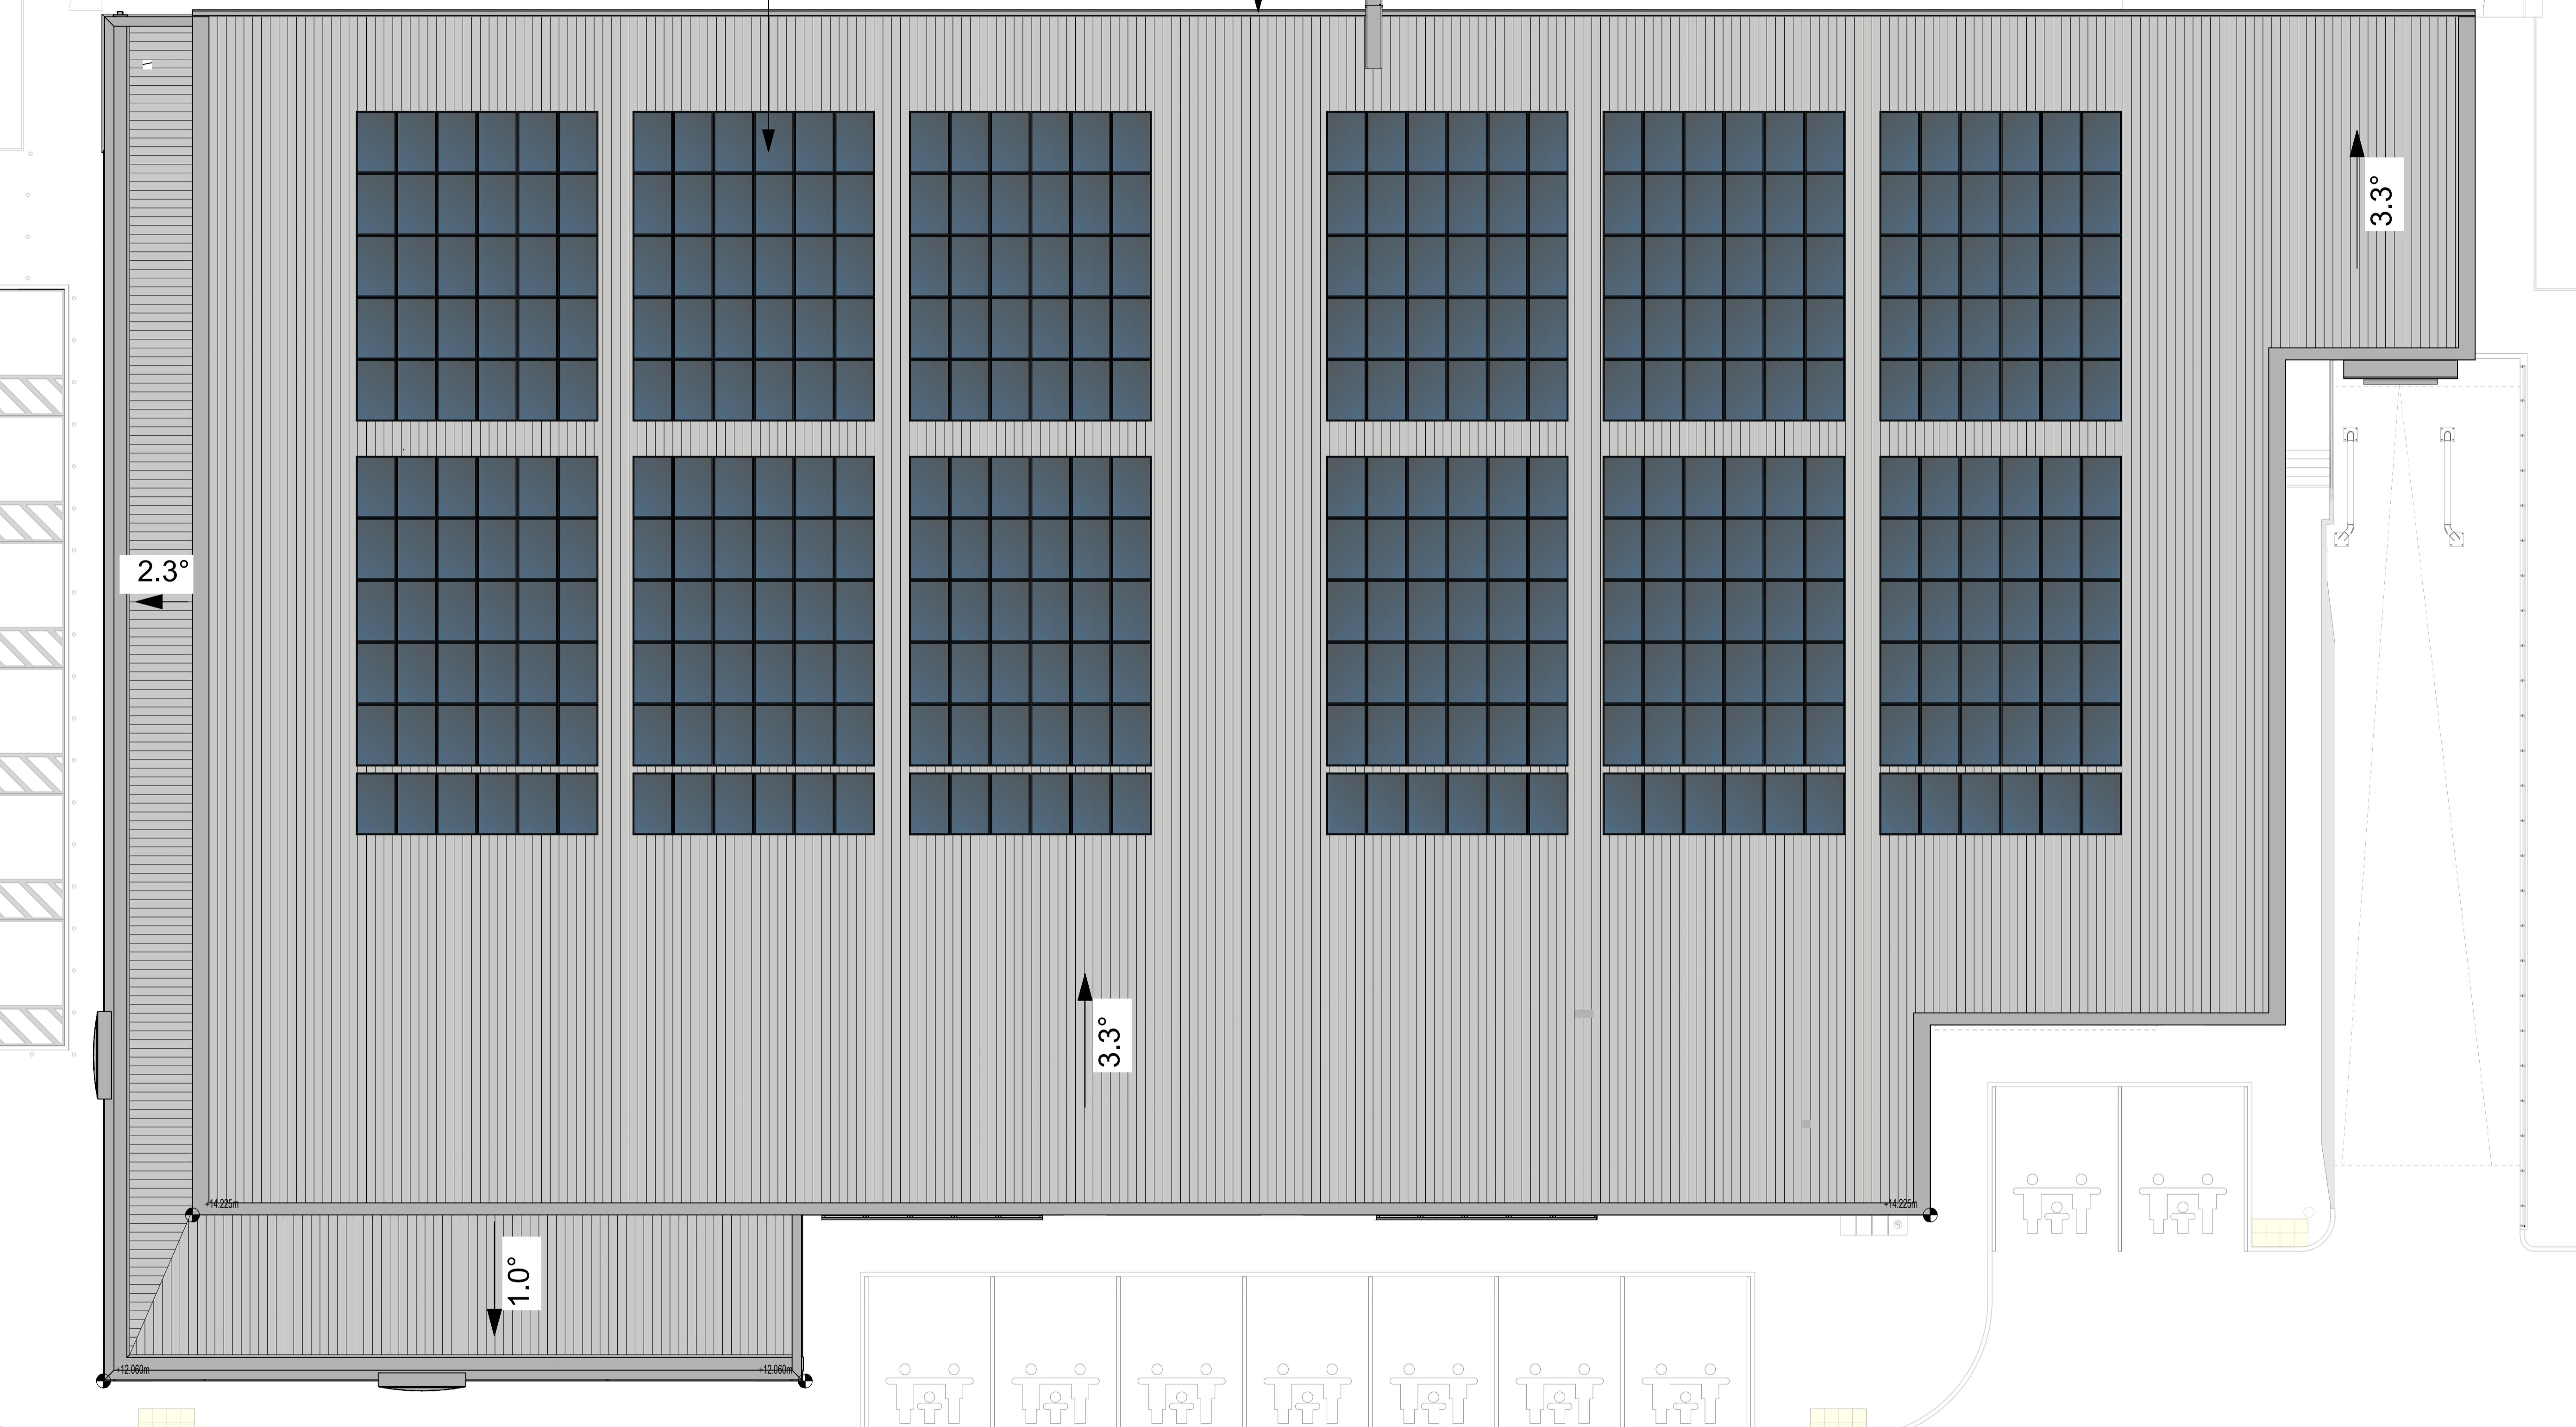

P00 FOR PLANNING  
Rev No. Description Drawn By Date

**URBAN EDGE**  
architecture / landscape / masterplanning

BRITISH LAND COMPANY PLC

Project:  
**NORTHERN QUARTER  
BROUGHTON SHOPPING PARK  
CHESTER**

Drawing:  
**FOOD STORE  
ROOF PLAN  
AS PROPOSED**

Issue Purpose:  
**FOR PLANNING**

Ref Proj No: 2960 Scale: 1:100 Date: JAN 26 Drawn: AS Status: Revision: P00  
Project: Organisation - Volume/System - Level - Type - Role - Number  
2960-URB-FS-RF-DR-A-208150