


## Lighting Notes

- Lighting design has been provided in accordance with the clients requirements, instructions and risk assessment.
- A maintenance factor of 0.80 has been used for the external lighting design. A maintenance factor of 1 has been used for the isoline export to represent a worst-case scenario of the 'Day 1' output.
- Visible Lighting Transmittance of the window glazing has been set to 70%.
- Lighting columns shall comply with all relevant standards, legislation, codes of practice, and industry good practice. In particular, but not limited to, lighting columns shall comply with BS EN 40.
- The contractor shall coordinate final column positions on site.
- Ducts shall be provided to route cables serving external lighting. These ducts shall be provided with a minimum of 2 in No. draw ropes and shall be sealed at both ends to prevent water / rodent ingress. All incoming and external ducts shall be via slow radius bends.
- All service trenches, draw pits and manhole / inspection covers to be sited away from all kerb lines, edges of raised paving, border lines, etc. All locations of said equipment to be agreed with the contract administrator.
- Labeling of accessories and equipment shall be by means of 3mm white/black/white plastic engineering material with 6mm characters to indicate associated service. All labels to be fixed by means of strong adhesive, brass screws and bolt or brass rivets. Non-durable 'stick-on' self-adhesive labels will not be acceptable.
- Internal column wiring: 3 core 2.5mm arctic grade (230V). Columns shall be labeled with a yellow self-adhesive band identifying the circuit it is fed from.
- Armco barriers or similar shall be provided to protect the root of each column to a minimum of 250mm above finished floor level.
- All works to be completed in accordance with BS 7671 including the latest amendments. Current British Standards, European Standards, Building Regulations, CIBSE Guidance, BSRIA Guidance and any industry standard practice guides.
- Safe cabling practices in accordance with HS(G)47 must be used to verify and establish the actual positions of electrical cables, gas mains, aer pipes, drainage and other services on site before any mechanical plant that is used. It is the contractors responsibility to ensure that this information is provided to any operative penetrating ground.
- Car Park lighting has been designed in accordance with BS 5489 - Table 4 for Outdoor Car Parking. This has been based on Light Traffic e.g., department stores, office buildings etc. 5  $E_{av}$ , 0.25  $U_0$ .
- Access roads have been designed in accordance with BS EN 12464-2:2024 Lighting of Outdoor Work Place and has been based on Table 7.2 Traffic areas for slowly moving vehicles  $E_m$  10.0lx, 0.40  $U_0$ .
- External Building Walkways have been designed in accordance with BS EN 12464-2:2024 Lighting of Outdoor Work Place and has been based on Table 7.1 Walkways exclusively for pedestrians  $E_p$  5.0lx, 0.20  $U_0$ .
- External lighting shall be controlled by timer and photocell. Timer shall be pre-set to switch 'on' 30 minutes before store opening times and 'off' 30 minutes after store closing time. The photocell shall be used to prevent the operation of external lighting during daylight hours.
- External lighting has been designed in accordance with ILP Guidance Note 1 for the Avoidance of Obtrusive Light, ILP Guidance Note 8 Bats and Artificial Lighting at Night and Good Practice Guidance: Planning for the Conservation and Enhancement of Dark Skies in Wales.
- All external luminaires shall be at 100% output unless stated otherwise.

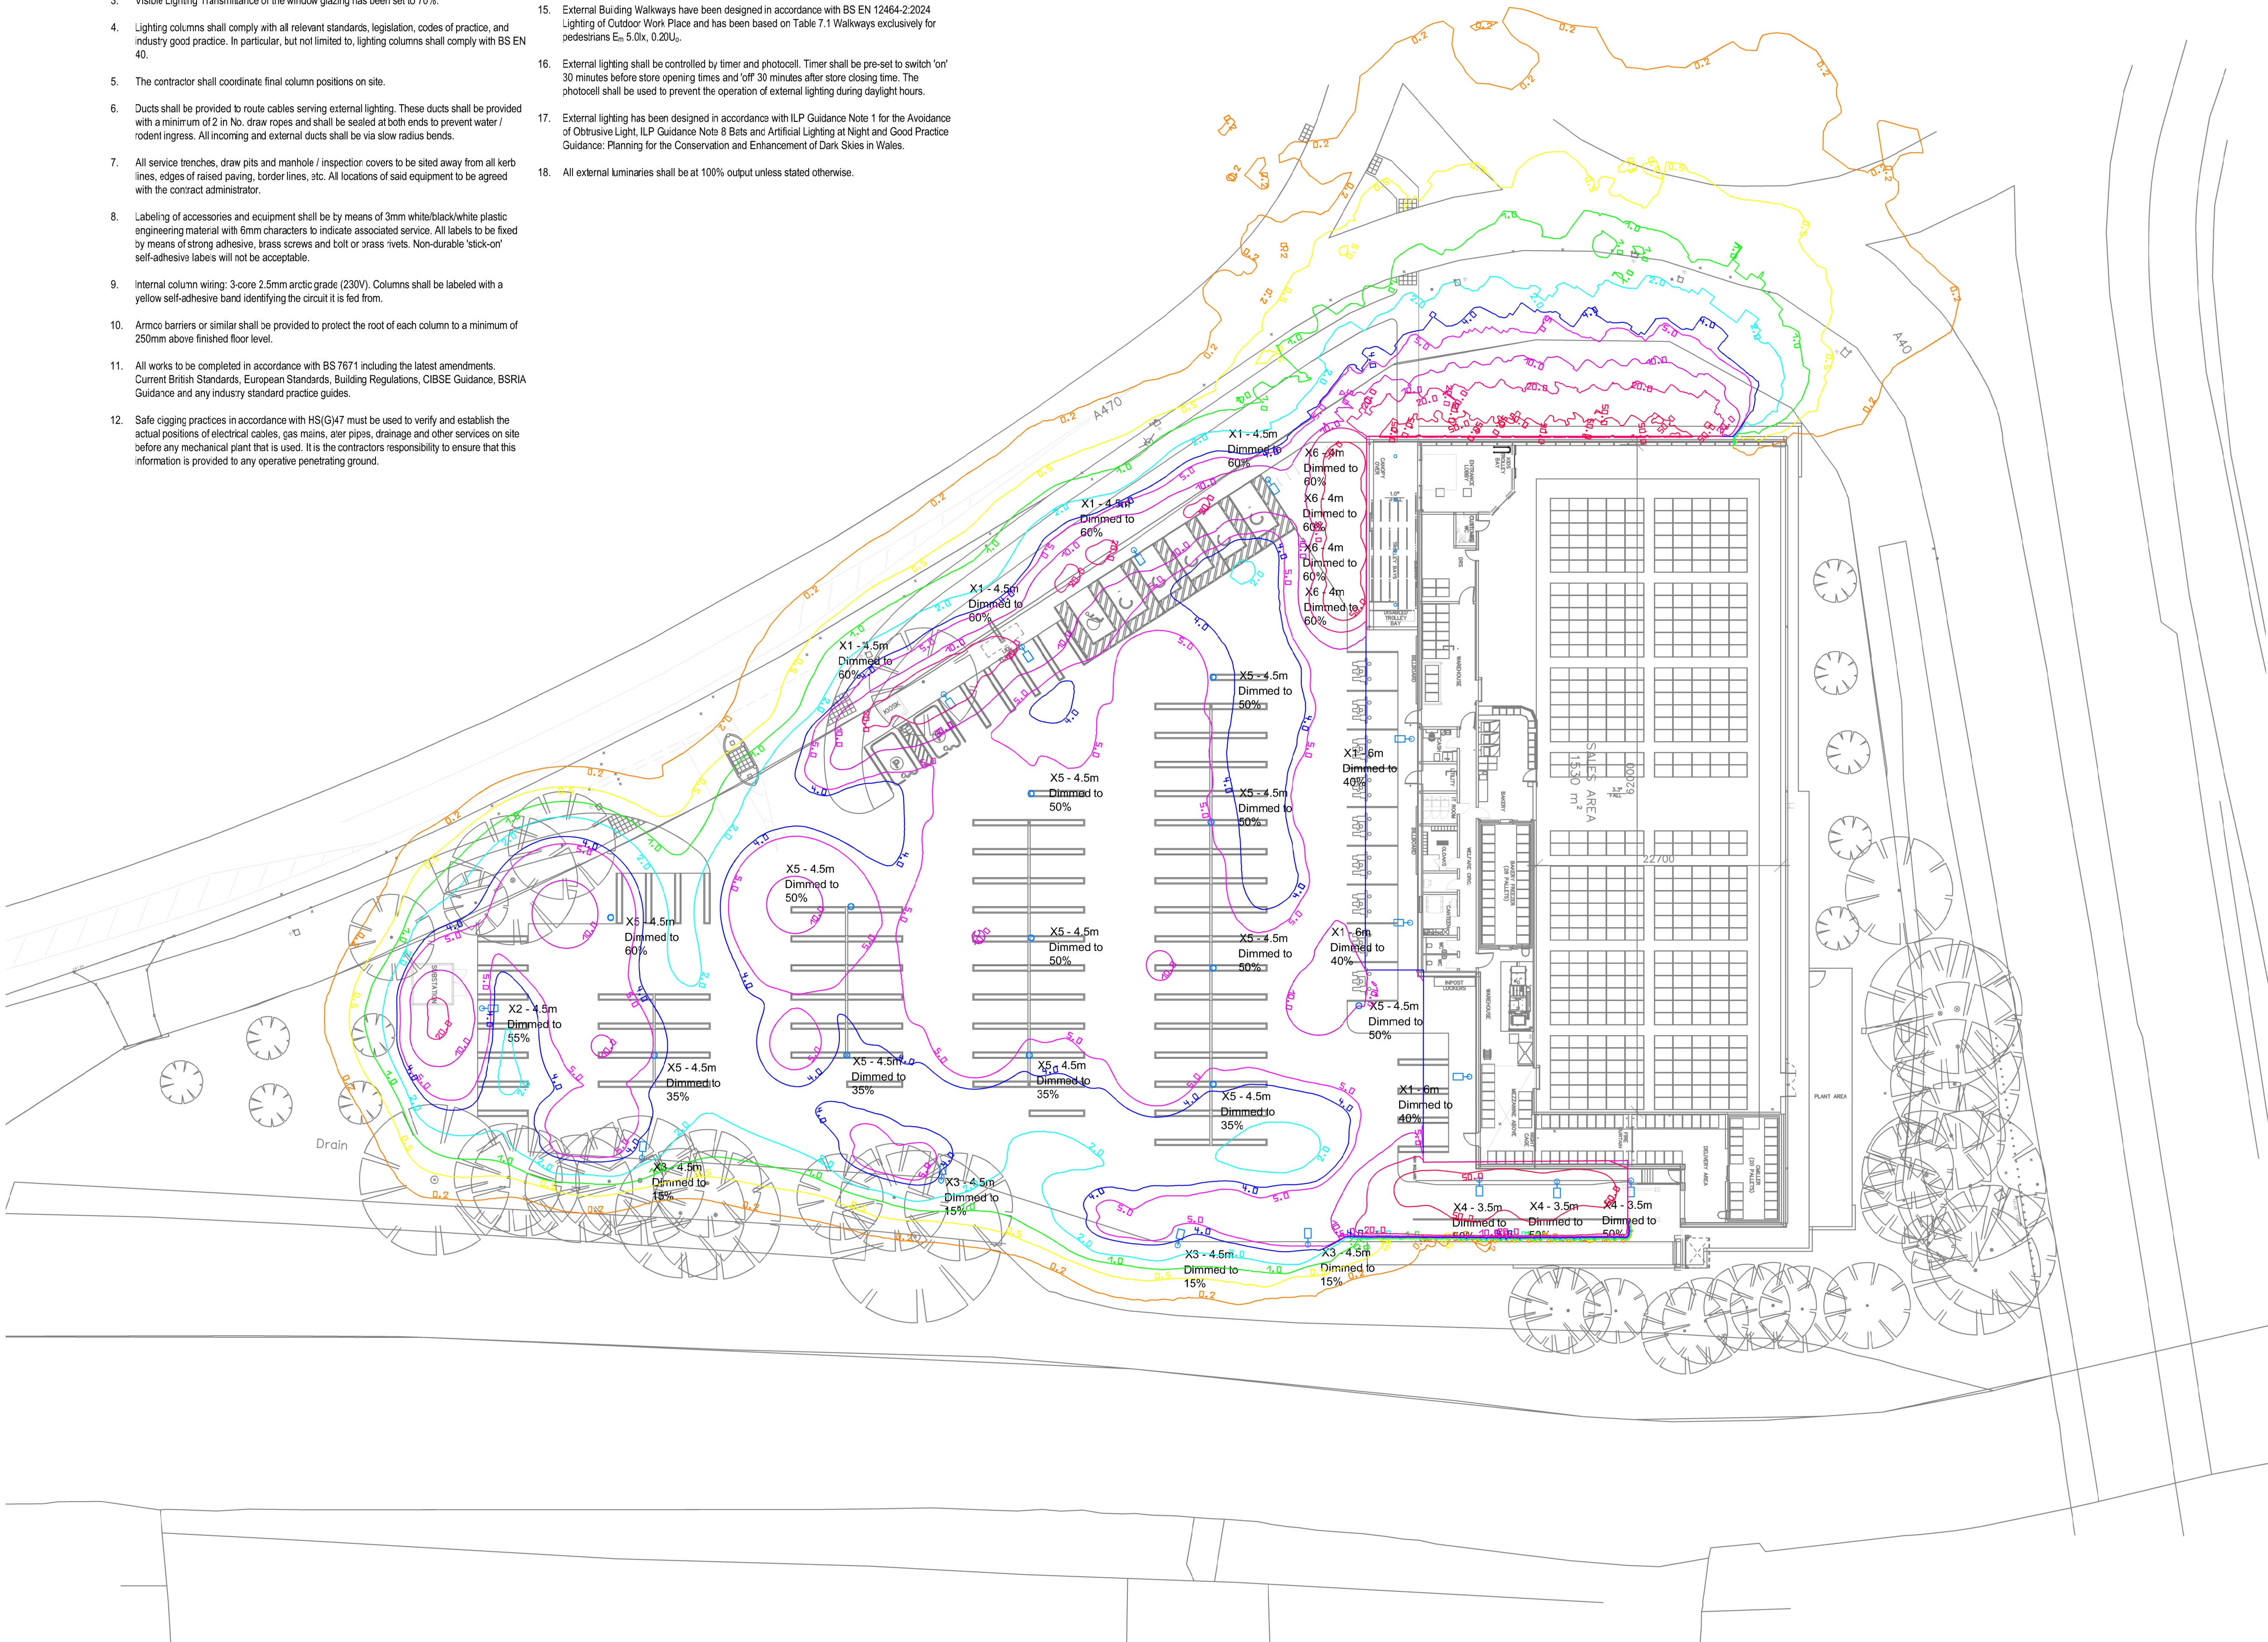

This Drawing is protected by Copyright. It may not be reproduced in any form or by any means for any purpose without the written consent of Services Design Solution Limited. All Dimensions to be checked on Site and verified prior to commencing Works / Manufacture. Any discrepancies to be reported to Services Design Solution Limited. These Drawings reflect the layouts for the purposes of design only. The Contractor shall be responsible for producing their own Working and Co-ordination drawings prior to commencing their installations. If these drawings are used for Construction purposes it is done so at the Contractor's Risk.

## SAFETY, HEALTH & ENVIRONMENTAL

Risk Level:

- ▲ Very Low
- ▲ Low
- ▲ Moderate
- ▲ High
- ▲ Very High

This drawing should be read in conjunction with the Designers risk assessment schedule', document number: 08998L-SDS-ZZ-ZZ-RG-E-7082008

All works should be carried out to an approved risk assessment and method statement.

## FIRE SAFETY AND CONFORMITY

All fixings within fire compartments (including fasteners, nuts, bolts, screws, anchors, cavity fixings, suspension fixings, beam clamps, pipe clamps, base plates, rod fixings, wire hangers, clips, and ties) shall be fire-rated for the specified fire resistance period of the compartment. Each type of fixing shall be accompanied by a fire-rated certificate of compliance and a Declaration of Conformity (DoC) or Certificate of Conformity (CoC). Additionally, photographic evidence must be provided to demonstrate that the installation complies with all relevant UK fire safety standards and regulations.

### Legend

- 0.2 Lux
- 0.5 Lux
- 1.0 Lux
- 2.0 Lux
- 4.0 Lux
- 5.0 Lux
- 10.0 Lux
- 20.0 Lux
- 50.0 Lux

### Luminaire Legend

- X1 Column mounted Fitting (see luminaire Schedule for information)
- X2 Column mounted Fitting (see luminaire Schedule for information)
- X3 Column mounted Fitting (see luminaire Schedule for information)
- X4 Column mounted Fitting (see luminaire Schedule for information)
- X5 Column mounted post top (see luminaire Schedule for information)
- X6 Downlight Fitting (see luminaire Schedule for information)

|     |                       |                 |            |
|-----|-----------------------|-----------------|------------|
| P03 | Titleblock Amendment  | GP / EH         | 25.08.2026 |
| P02 | Updates from Comments | KT / EH         | 24.08.2026 |
| P01 | Preliminary Issue     | KT / EH         | 28.08.2026 |
| Rev | Details               | By / Ck'd / App | Date       |



SERVICES DESIGN SOLUTION LIMITED  
Herbert House, Pymme Hill, Rydon Lane  
Exeter, Devon, EX2 8AZ  
Tel +44 (0)1392 444105 | www.sdsolution.co.uk

CLIENT



PROJECT TITLE  
**Brecon Lidl**  
Land off A470  
Brecon, Powys, LD3 8LA

DRAWING TITLE  
**Horizontal Illuminance at Ground Level**  
Combined Internal and External  
External Lighting

SCALE AT A1  
1:300

DISCIPLINE  
Lighting

DRAWING NUMBER  
**08998L-SDS-ZZ-EX-D-E-7082005**

Project - Originator - Zone - Level - Type - Role - NBS class - Sequential Number

STATUS  
Review & Authorisation

SUITABILITY  
S3

ISSUE  
P03